


Drawing: S:\Projects\2024\2434900 - SOM MSP Headquarters Elevator Upgrade\Drawings\ME\500-2434900.dwg
 Date: Feb 27, 2025, 2:26pm Layout: 2434900

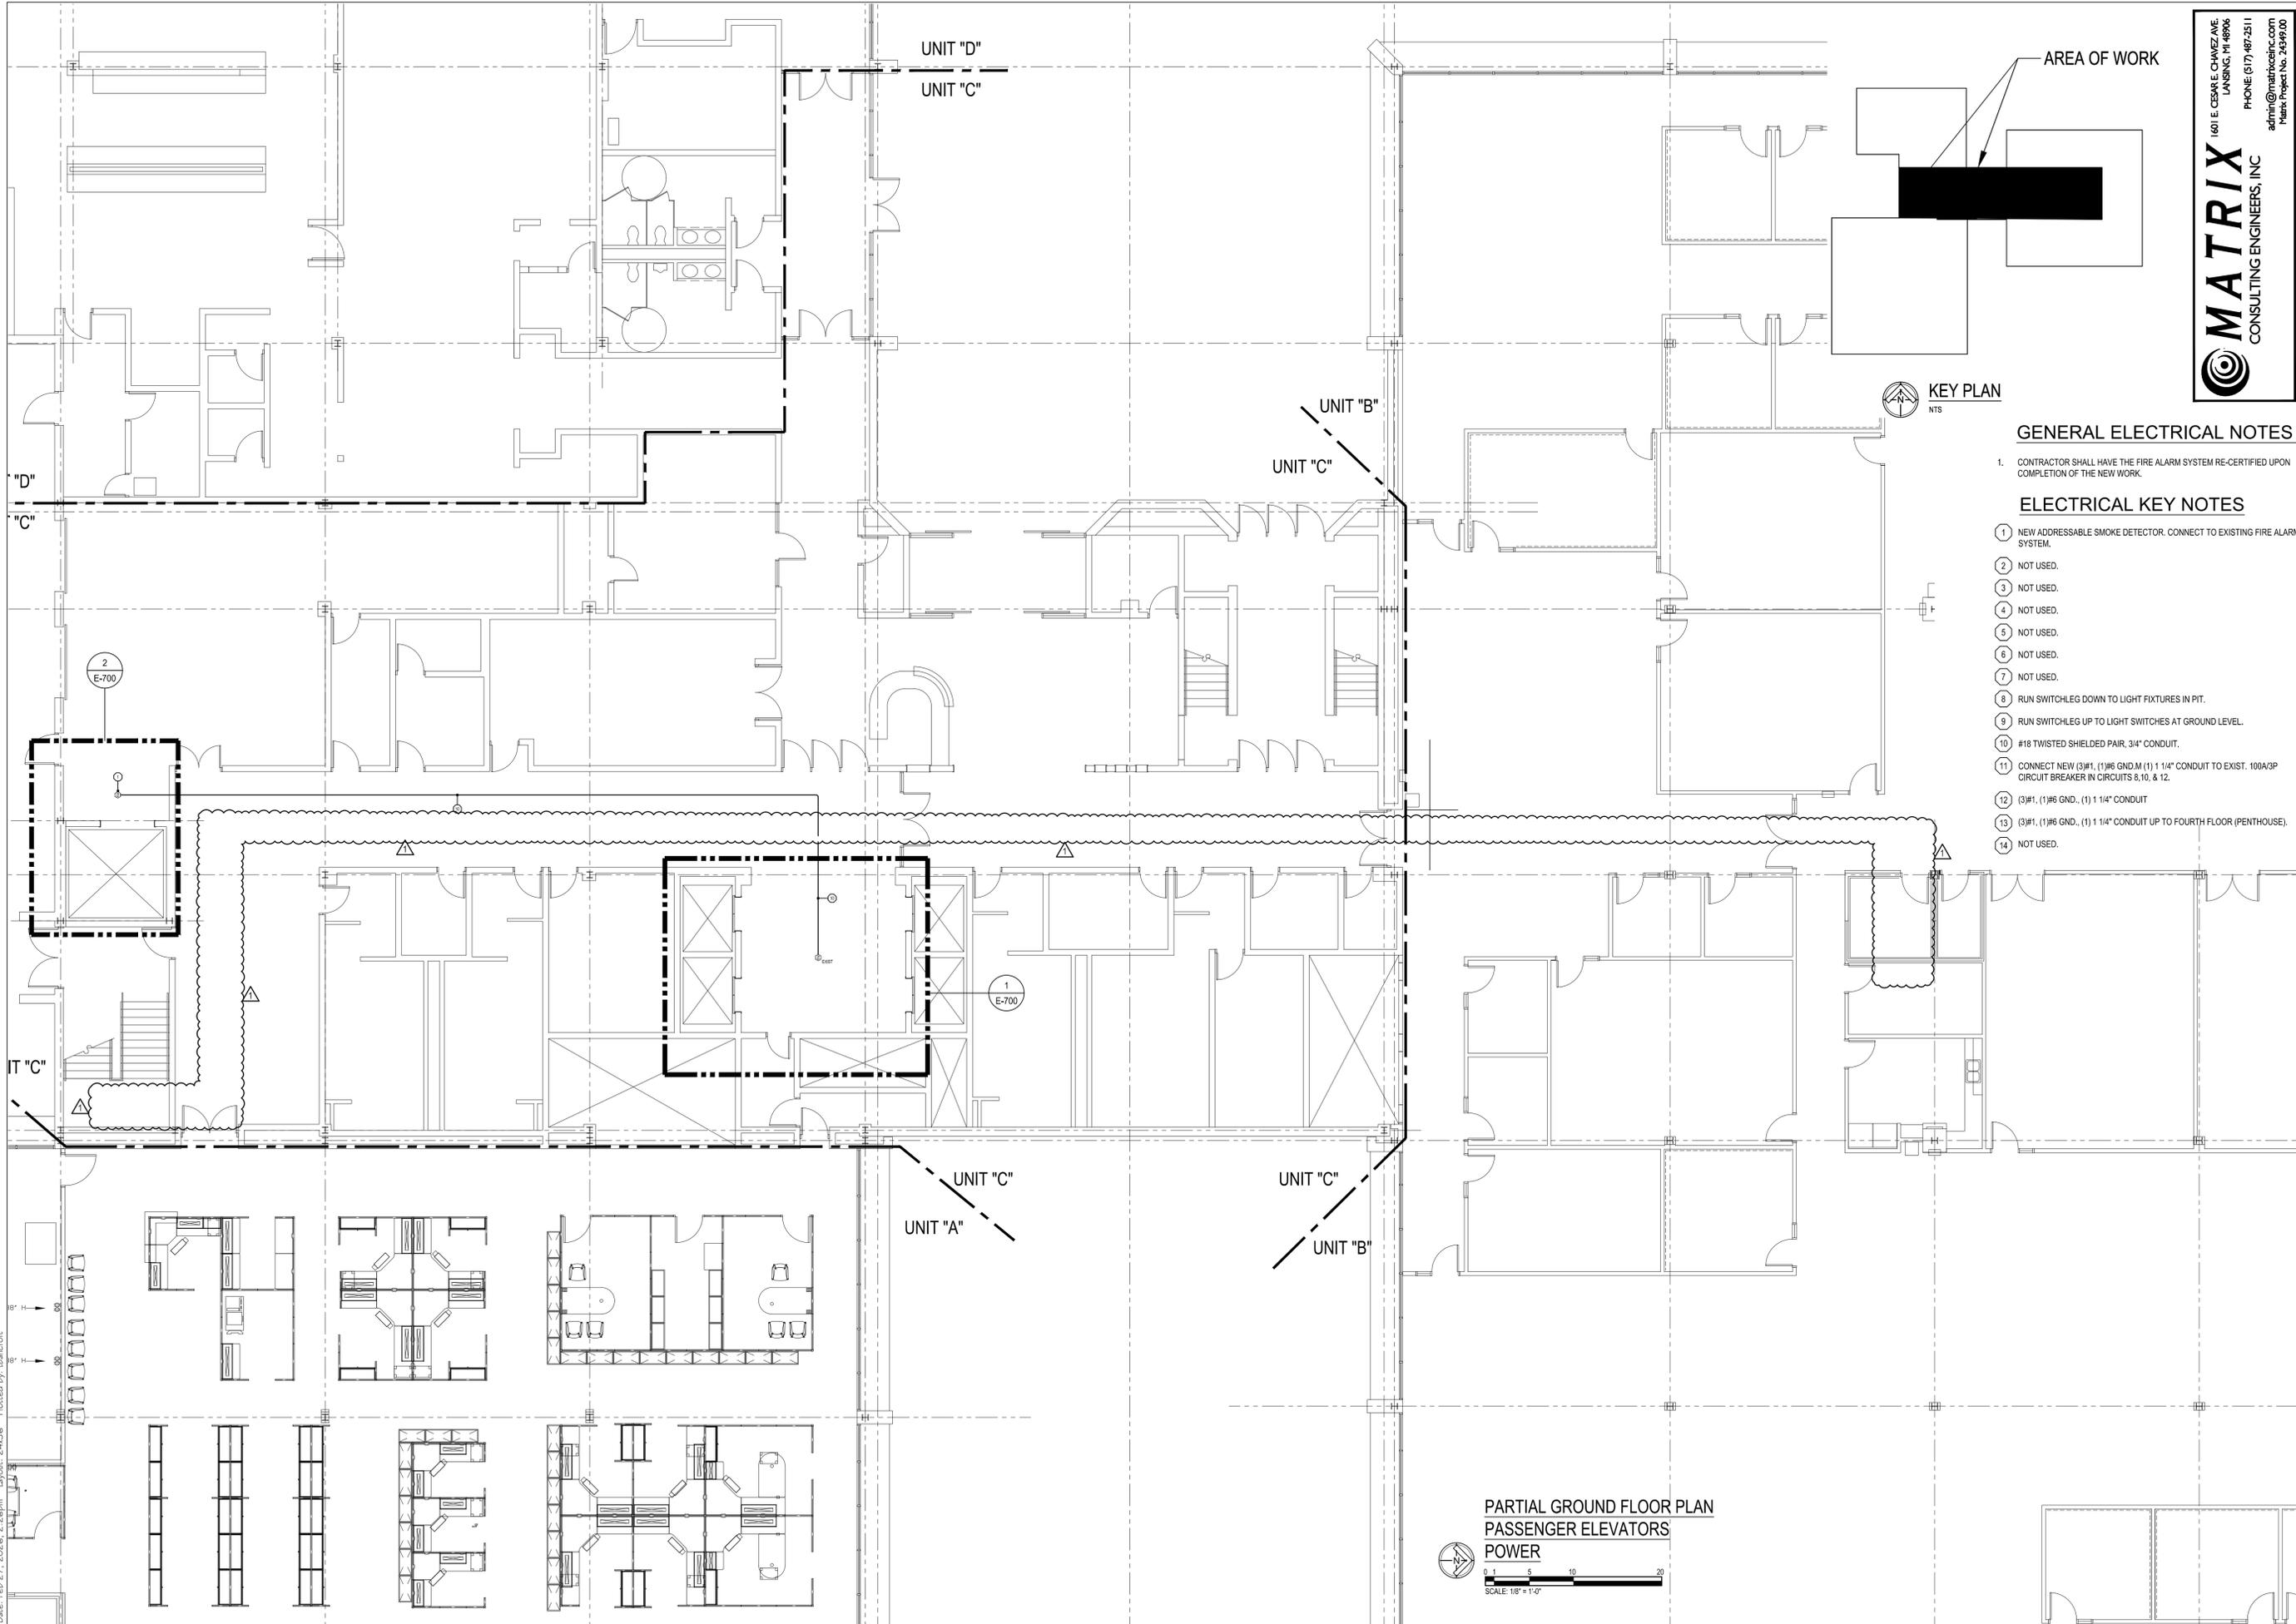

MATRIX
 CONSULTING ENGINEERS, INC.
 1601 E. CESAR E. CHAVEZ AVE.
 LANSING, MI 48906
 PHONE: (313) 487-2511
 admin@matrixinc.com
 Matrix Project No. 2434900

STATE OF MICHIGAN
 DEPARTMENT OF TECHNOLOGY, MANAGEMENT AND BUDGET
 PROCUREMENT AND REAL ESTATE SERVICES ADMINISTRATION
 DESIGN AND CONSTRUCTION DIVISION
 ADAM P. LACH, RA, DIRECTOR

**MSP HEADQUARTERS
 UPGRADE ELEVATORS**

**ELECTRICAL
 FIRST FLOOR PLAN
 POWER**

**HOBBS + BLACK
 ARCHITECTS**
 1777 Grand River Ave.
 Grand Rapids, MI 49503
 www.hobbs-black.com
 H+B No. 24-316

DESIGNED	TRB
DRAWN	TRB
CHECKED	JFS
APPROVED	

ISSUED FOR	DATE
50% PROGRESS SET	11/26/2025
ISSUED FOR BIDS	02/09/2026
ADDENDUM #1	02/27/2026

SHEET IDENTIFICATION NO.
 FILE NUMBER: 171724099.TYC
 STATE INDEX NUMBER: Y 24380



GENERAL ELECTRICAL NOTES

- CONTRACTOR SHALL HAVE THE FIRE ALARM SYSTEM RE-CERTIFIED UPON COMPLETION OF THE NEW WORK.


ELECTRICAL KEY NOTES

- NEW ADDRESSABLE SMOKE DETECTOR. CONNECT TO EXISTING FIRE ALARM SYSTEM.
- NOT USED.
- RUN SWITCHLEG DOWN TO LIGHT FIXTURES IN PIT.
- RUN SWITCHLEG UP TO LIGHT SWITCHES AT GROUND LEVEL.
- #18 TWISTED SHIELDED PAIR, 3/4" CONDUIT.
- CONNECT NEW (3)#1, (1)#6 GND.M (1) 1 1/4" CONDUIT TO EXIST. 100A/3P CIRCUIT BREAKER IN CIRCUITS 8,10, & 12.
- (3)#1, (1)#6 GND., (1) 1 1/4" CONDUIT
- (3)#1, (1)#6 GND., (1) 1 1/4" CONDUIT UP TO FOURTH FLOOR (PENTHOUSE).
- NOT USED.

**PARTIAL GROUND FLOOR PLAN
 PASSENGER ELEVATORS
 POWER**

SCALE: 1/8" = 1'-0"

Drawing: S:\Projects\2024\2434800 - SOM MSP Headquaters Elevator Upgrades\Drawings\W\EL502-2434800.dwg
 Date: Feb 27, 2025, 2:27 pm Layout: 24343C Plotted by: Bancroft

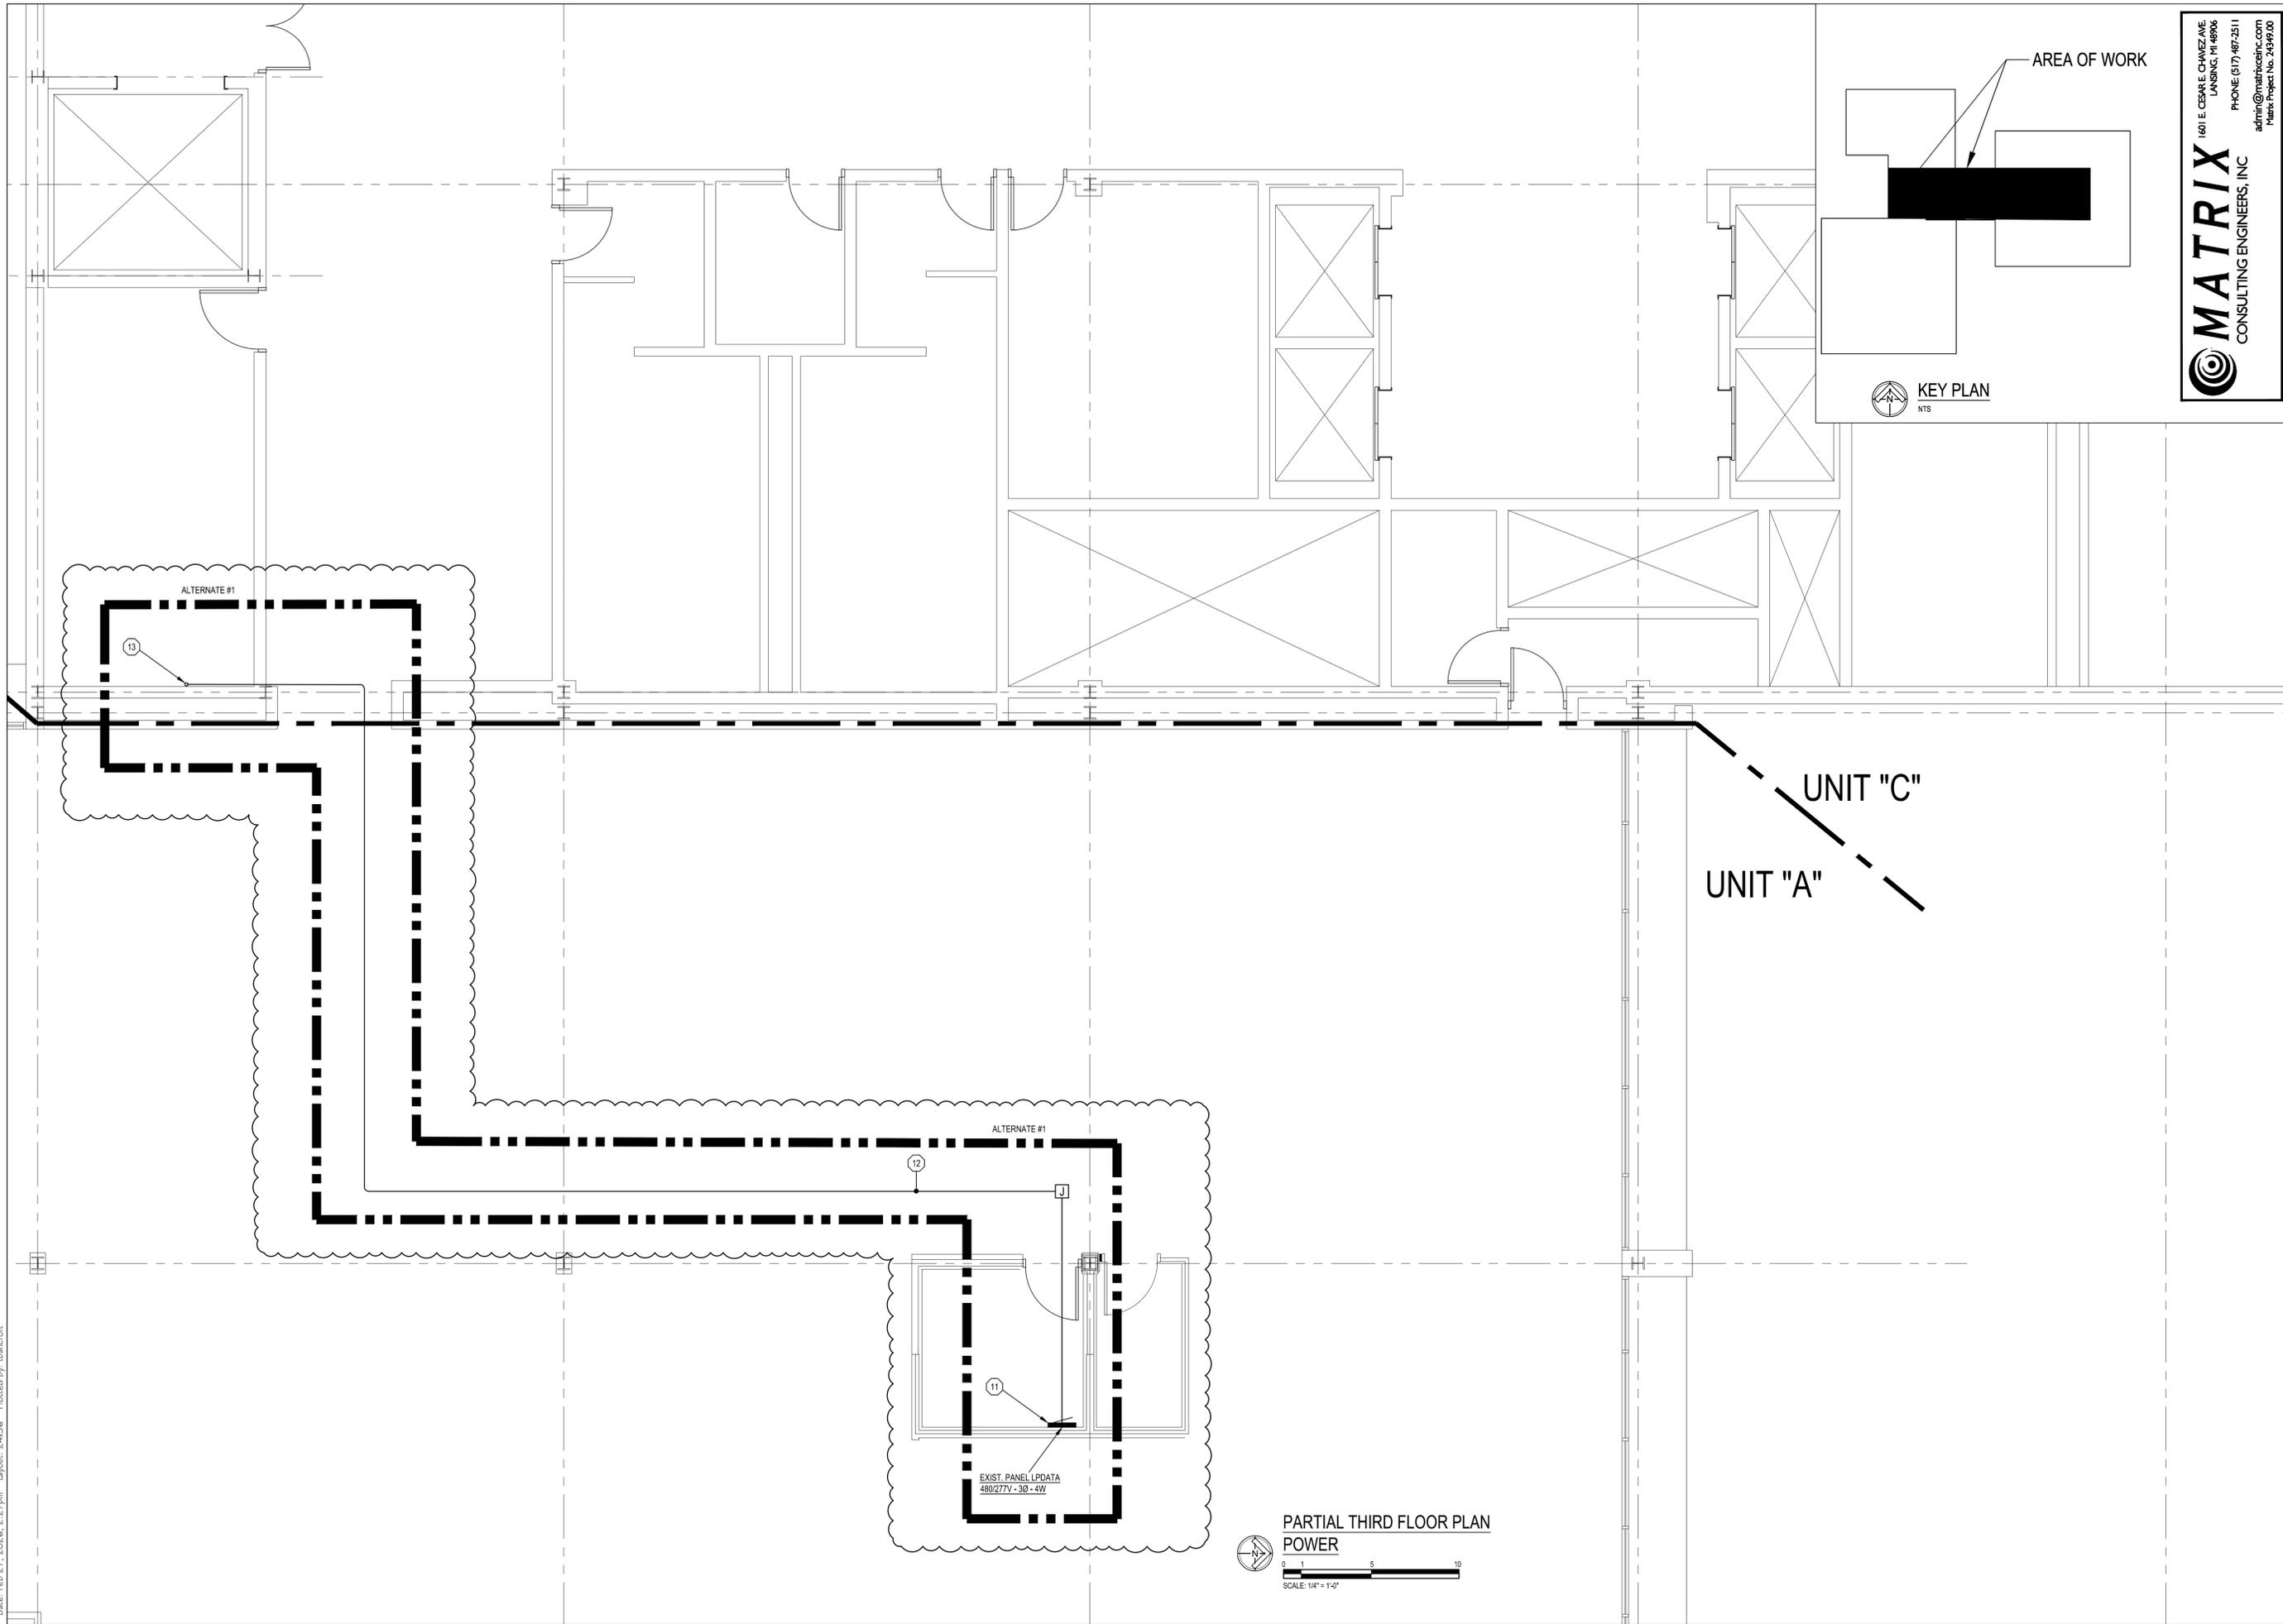

MATRIX
 CONSULTING ENGINEERS, INC.
 1601 E. CESAR E. CHAVEZ AVE.
 LANSING, MI 48906
 PHONE: (313) 487-2511
 admin@matrixinc.com
 Matrix Project No. 24343C

STATE OF MICHIGAN
 DEPARTMENT OF TECHNOLOGY, MANAGEMENT AND BUDGET
 PROCUREMENT AND REAL ESTATE SERVICES ADMINISTRATION
 DESIGN AND CONSTRUCTION DIVISION
 ADAM P. LACH, RA, DIRECTOR

**MSP HEADQUARTERS
 UPGRADE ELEVATORS**
 7160 Harris Dr.
 Dimondale, MI 48821

**ELECTRICAL
 FIRST FLOOR PLAN
 POWER**

**HOBBS + BLACK
 ARCHITECTS**
 1174 Angier Street
 Durham, NC 27601
 www.hobbs-black.com
 H+B No. 24-316

DESIGNED	TRB
DRAWN	TRB
CHECKED	JFS
APPROVED	.

ISSUED FOR	DATE
50% PROGRESS SET	11/26/2025
ISSUED FOR BIDS	02/09/2026
ADDENDUM #1	02/27/2026

IDENTIFICATION NO.	FILE NUMBER:
171724099.TYC	171724099
STATE INDEX NUMBER:	Y 24380

SHEET
E-502